


PUMP PIPING PLAN SCALE: 1/4" = 1'

— ROTATE HANDWHEEL —> 90° AS SHOWN



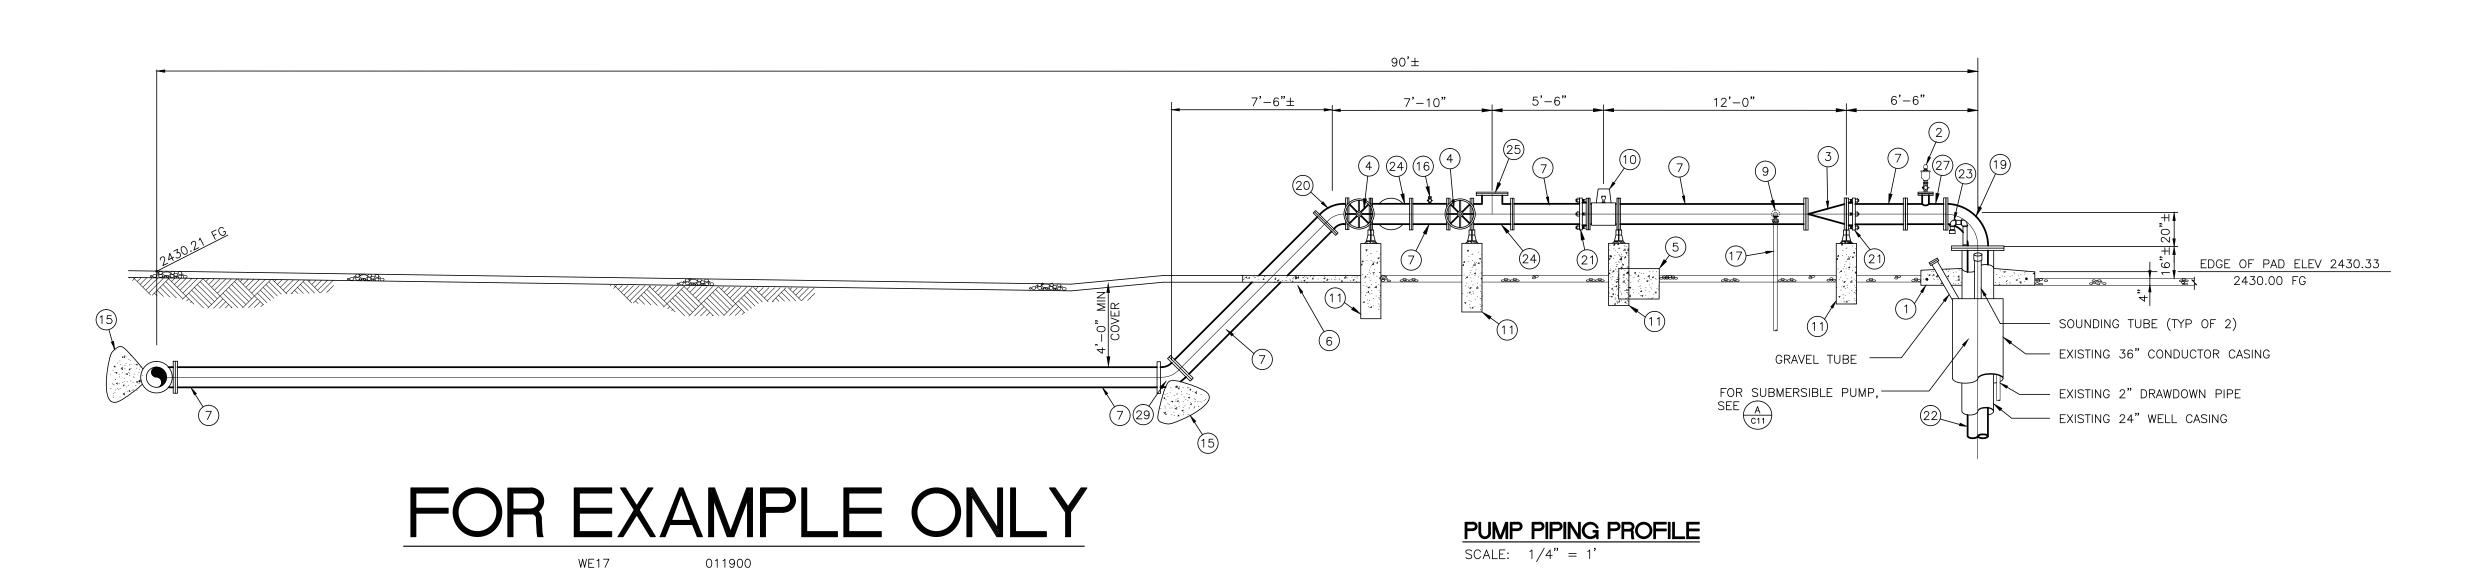

	, uE							BENCHMARK:	
	TINGO, WAME,								i
ONFER'S	INSERT CONSULTANT LOGO, HERE ADDRESS AND PHONE NO.								
INSERT ENGINEER'S INSERT ENGINEER'S	INSERT COLAND FILE			_					i
STAMI	ADURLO								I
									1
	APPROVED BY:DATE:	MARK	REVISIONS	APPROVED	DATE	APPROVED	DATE		1
FNGINFFR'S SFAI	REGISTERED CIVIL ENGINEER No. XXXXX	DESIGNED BY: XX	DRAWN BY: XX CHECKED BY: XX	DESIGN EN	NGINEER	SBMWD EN	GINEER	ELEV.= XXXX.XX FT.	I

DRAWING SCALES:

HORIZ: N/A VERT: N/A

XXXX

DWG C2

CITY OF SAN BERNARDINO MUNICIPAL WATER DEPARTMENT

WELL NO. XXXX

PIPING PLAN